


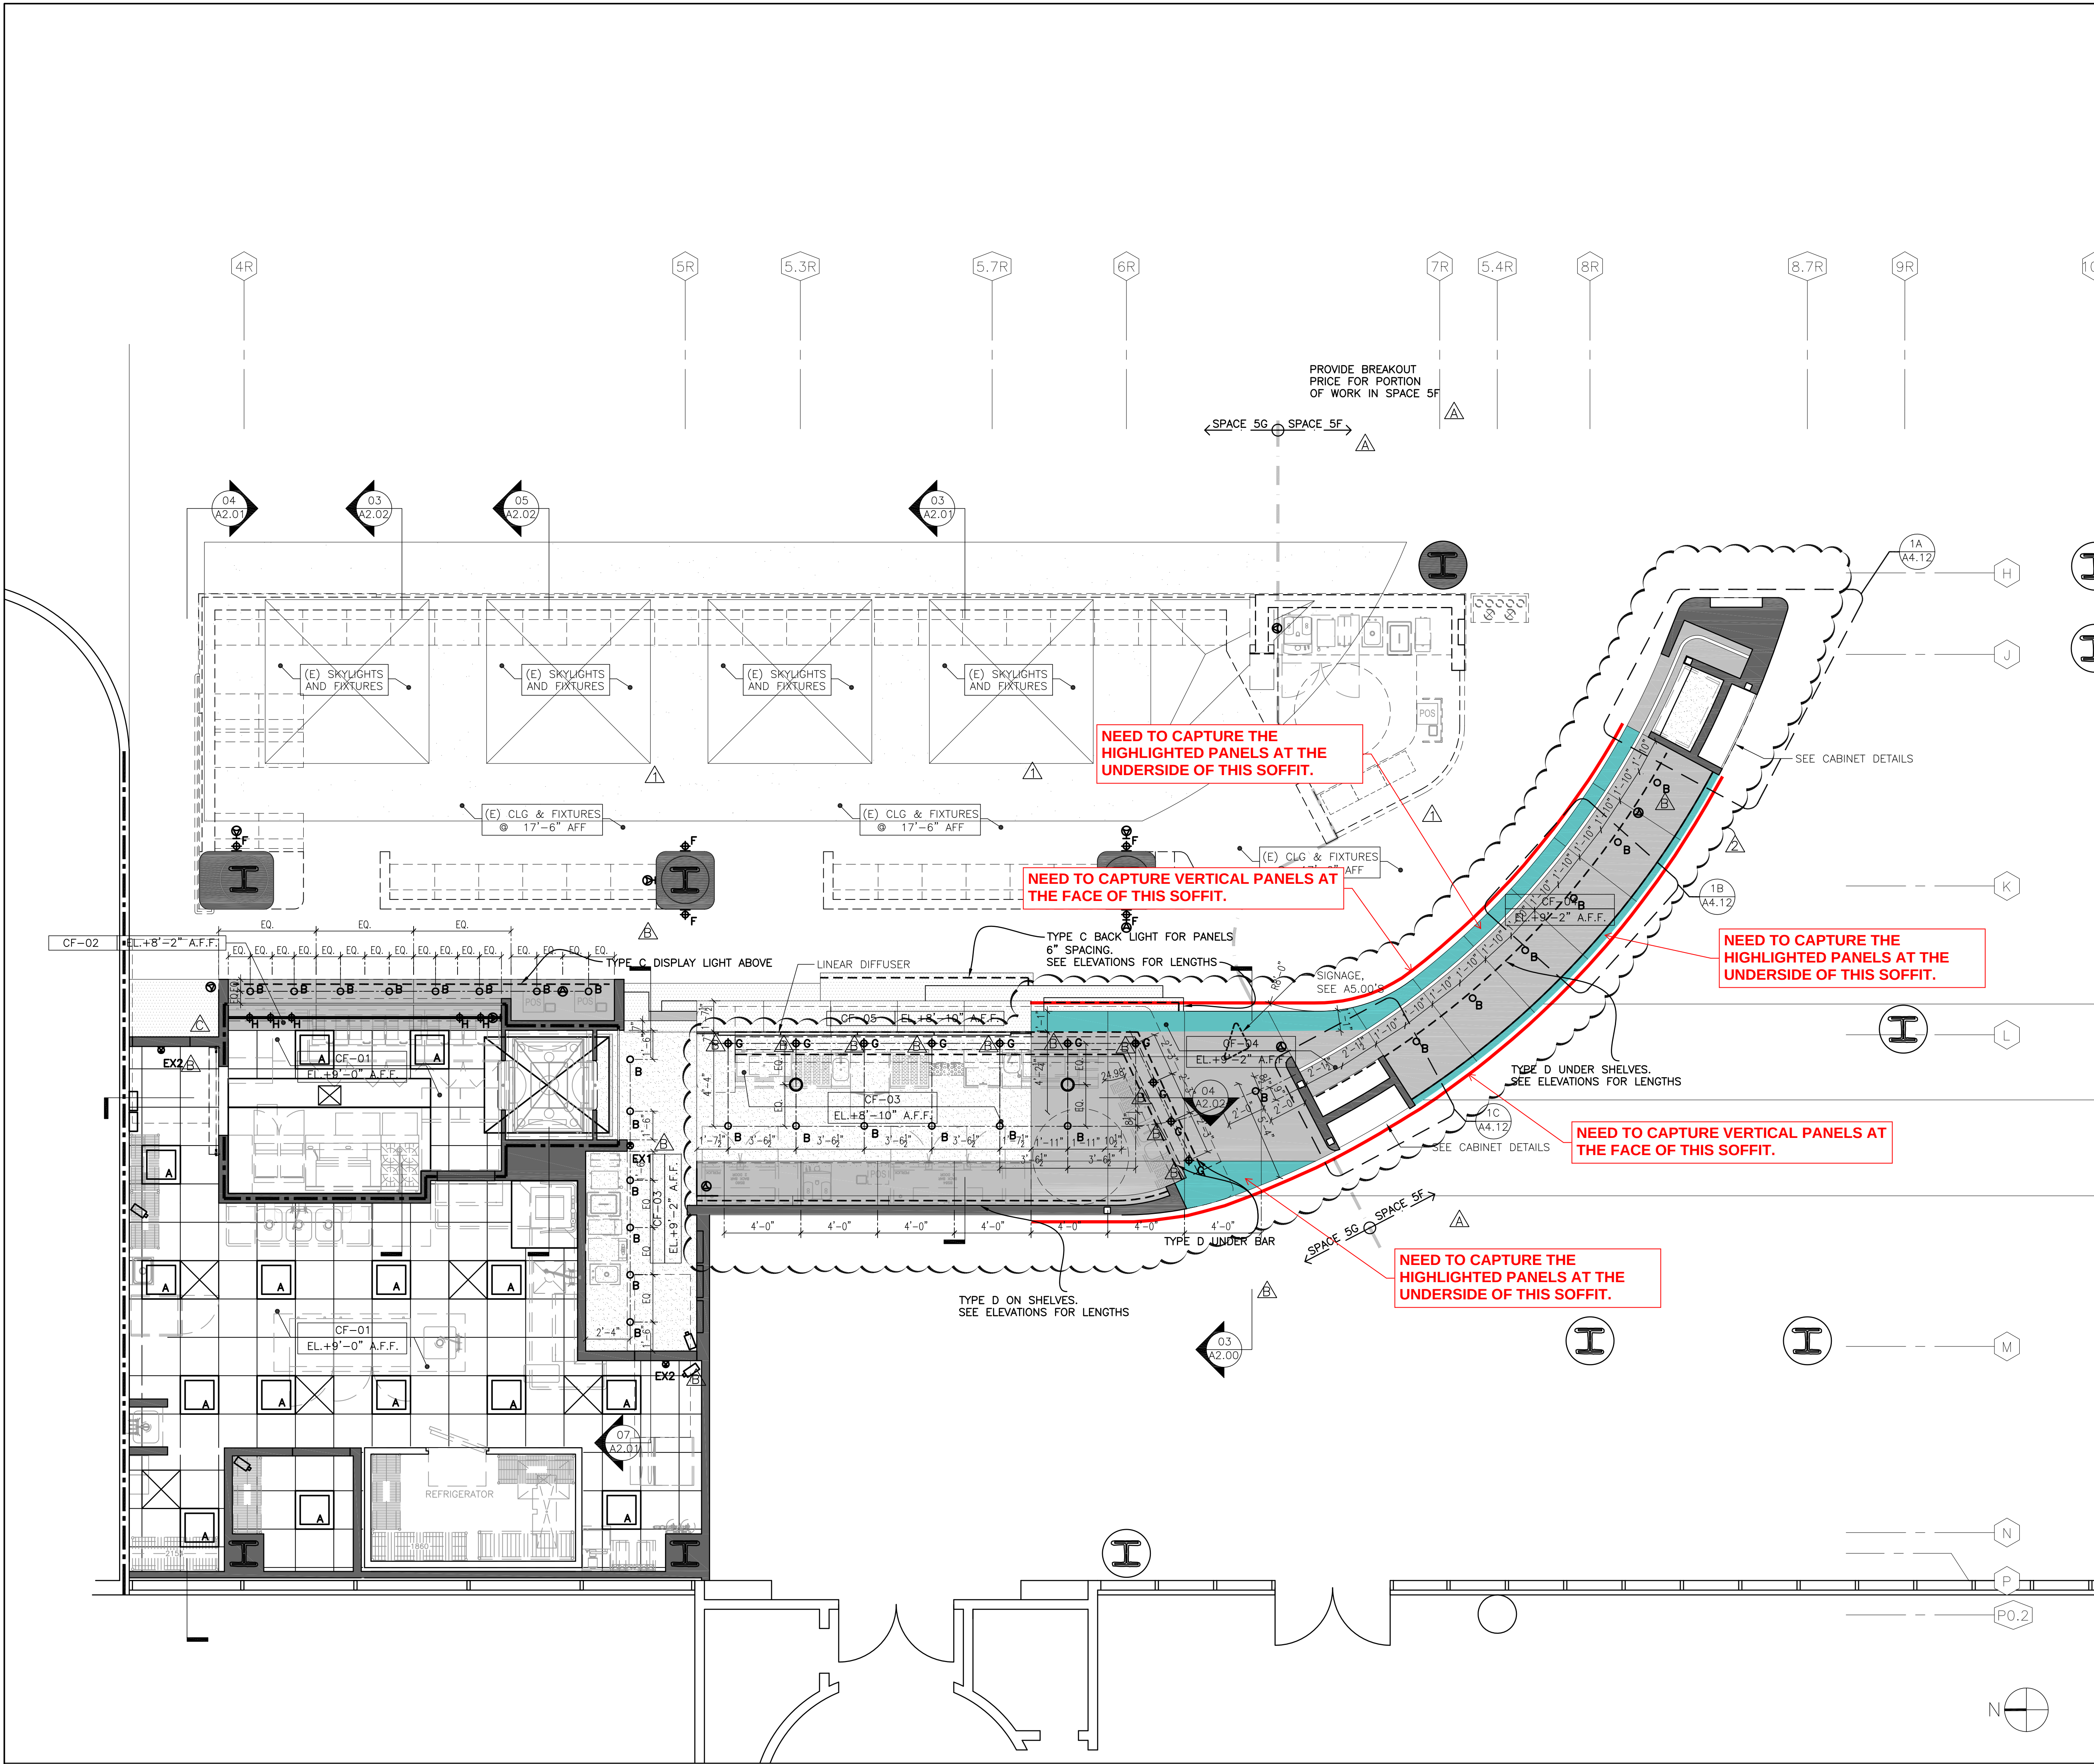

R C P L E G E N D

- A RECESSED FLUORESCENT LIGHT
- B RECESSED DOWNLIGHT
- C CONCEALED LED STRIP LIGHT
- D CONCEALED LED STRIP LIGHT
- F SCONCE LIGHT
- G PENDANT LIGHT
- STAINLESS STEEL
- HDF (HIGH DENSITY FIBERBOARD) PAINTED
- LOW V.O.C. PAINTED GYP. BD.
- 1HR SEPARATION
- EXISTING WALL
- NEW WALL
- SPRINKLER HEAD —SEE FIRE SPRINKLER PLAN

R C P N O T E S

- FOR LIGHT FIXTURE SCHEDULE SEE ELECTRICAL DRAWINGS.
- DIVISIONS & GEOMETRY OF S.S. (& OTHER PANELIZED MATERIALS) CEILING & SOFFIT PANELS MUST BE APPROVED BY THE ARCHITECT.

CORSINI STARK architects

Corsini Stark Architects, LLP
3630 Tyburn Street
Los Angeles, CA 90065

t 323 255 9100
f 323 255 9105
w corsinistark.com

All ideas, designs, arrangements, and plans indicated or represented by these drawings are owned by and are the property of Corsini Stark Architects, LLP and shall remain confidential, and developed for use on, and in connection with the specified project. None of such ideas, designs, arrangements, or plans shall be used by or disclosed to any person, firm, or corporation, without the written permission of Corsini Stark Architects, LLP.

PROFESSIONAL SEAL:

CONSULTANTS:

MEP ENGINEERS:

DAVIDOVICH AND ASSOCIATES
6058 BRISTOL PARKWAY
2ND FLOOR
CULVER CITY, CA 90230
T: 310.348.5101 F: 310.348.5102
MECHANICAL: SHAHROKH SAREMI
ELECTRICAL: DENNIS SESE
PLUMBING: GILAD NAHARI

STRUCTURAL ENGINEERS:

BRANDOW & JOHNSON, INC.
700 SOUTH FLOWER STREET
LOS ANGELES, CA 90017
T: 213.596.4504 F: 213.596.4599
CONTACT: KIM CARAVALHO

KITCHEN DESIGN:

LASCHOVER + SOVICH
20301 VENTURA BLVD.
SUITE 338
WOODLAND HILLS, CA 91364
T: 818.713.9011

#	SUBMISSIONS / REVISIONS	DATE
	LAWA SUBMISSION #2 DESIGN DEVELOPMENT / 60% COMPLETION	04.27.2012
	LAWA SUBMISSION #3 DESIGN DEVELOPMENT / 90% COMPLETION	08.13.2012
Δ	ADDENDUM A	09.30.2012
	PERMIT SET	10.01.2012
Δ	V.E. REVISIONS	01.18.2013
Δ	LAWA SUBMISSION #4 100% COMPLETION	02.22.2013
Δ	ISSUE FOR CONSTRUCTION	04.15.2013
Δ	ADDITIONAL LIGHTING	07.01.2013
Δ	RECORD DRAWINGS	08.04.2013

PROJECT TITLE:

Los Angeles Times

LOS ANGELES INTERNATIONAL AIRPORT
550 WORLD WAY
LOS ANGELES, CA 90045

TERMINAL 5 / SPACE 5G-F

DRAWING TITLE:

REFLECTED CEILING PLAN

DRAWING NUMBER:

A1.02